

- FACP

ADDRESSABLE FIRE ALARM CONTROL PANEL
- NAC

N/A
- AES

AES RADIO BOX
- K

KNOX BOX SURFACE MOUNTED
- F

ADDRESSABLE MANUAL PULL STATION
- S

ADDRESSABLE SMOKE DETECTOR
- S

NOT USED
- S

NOT USED
- R

NOT USED
- H

ADDRESSABLE 135 ROR HEAT DETECTOR
- F

HORN STROBE UNIT
- WP

WP STROBE ONLY UNIT
- A

STROBE ONLY UNIT
- F

NOT USED
- S


NOT USED
- MM

ADDRESSABLE MONITOR MODULE
- EOL
- END OF LINE DEVICE

FIRE ALARM LEGEND

FIRE ALARM DEVICE SCHEDULE		
ADD	TYPE	DESCRIPTION
L1-D01	SMOKE	RECEPTION
L1-D02	SMOKE	RECEPTION
L1-D03	SMOKE	OFFICE
L1-D04	SMOKE	CONFERENCE ROOM
L1-D05	SMOKE	OFFICE HALLWAY
L1-D06	SMOKE	BATHROOM
L1-D07	SMOKE	BATHROOM
L1-D08	SMOKE	BASEMENT STAIRWAY
L1-D09	SMOKE	BASEMENT
L1-D10	SMOKE	OFFICE
L1-D11	SMOKE	OFFICE
L1-D12	HEAT DET	GARAGE
L1-D13	HEAT SET	SOUTH WAREHOUSE
L1-D14	HEAT DET	SOUTH WAREHOUSE
L1-D15	HEAT DET	GARAGE
L1-D16	SMOKE	EAST WAREHOUSE
L1-D17	SMOKE	EAST WAREHOUSE
L1-D18	SMOKE	EAST WAREHOUSE

FIRE ALARM MODULE SCHEDULE		
ADD	TYPE	DESCRIPTION
L1-M01	PULL STATION	WEST EGRESS
L1-M02	PULL STATION	NORTH EGRESS
L1-M03	MON MODULE	AES TROUBLE
N/A	N/A	N/A
N/A	N/A	N/A

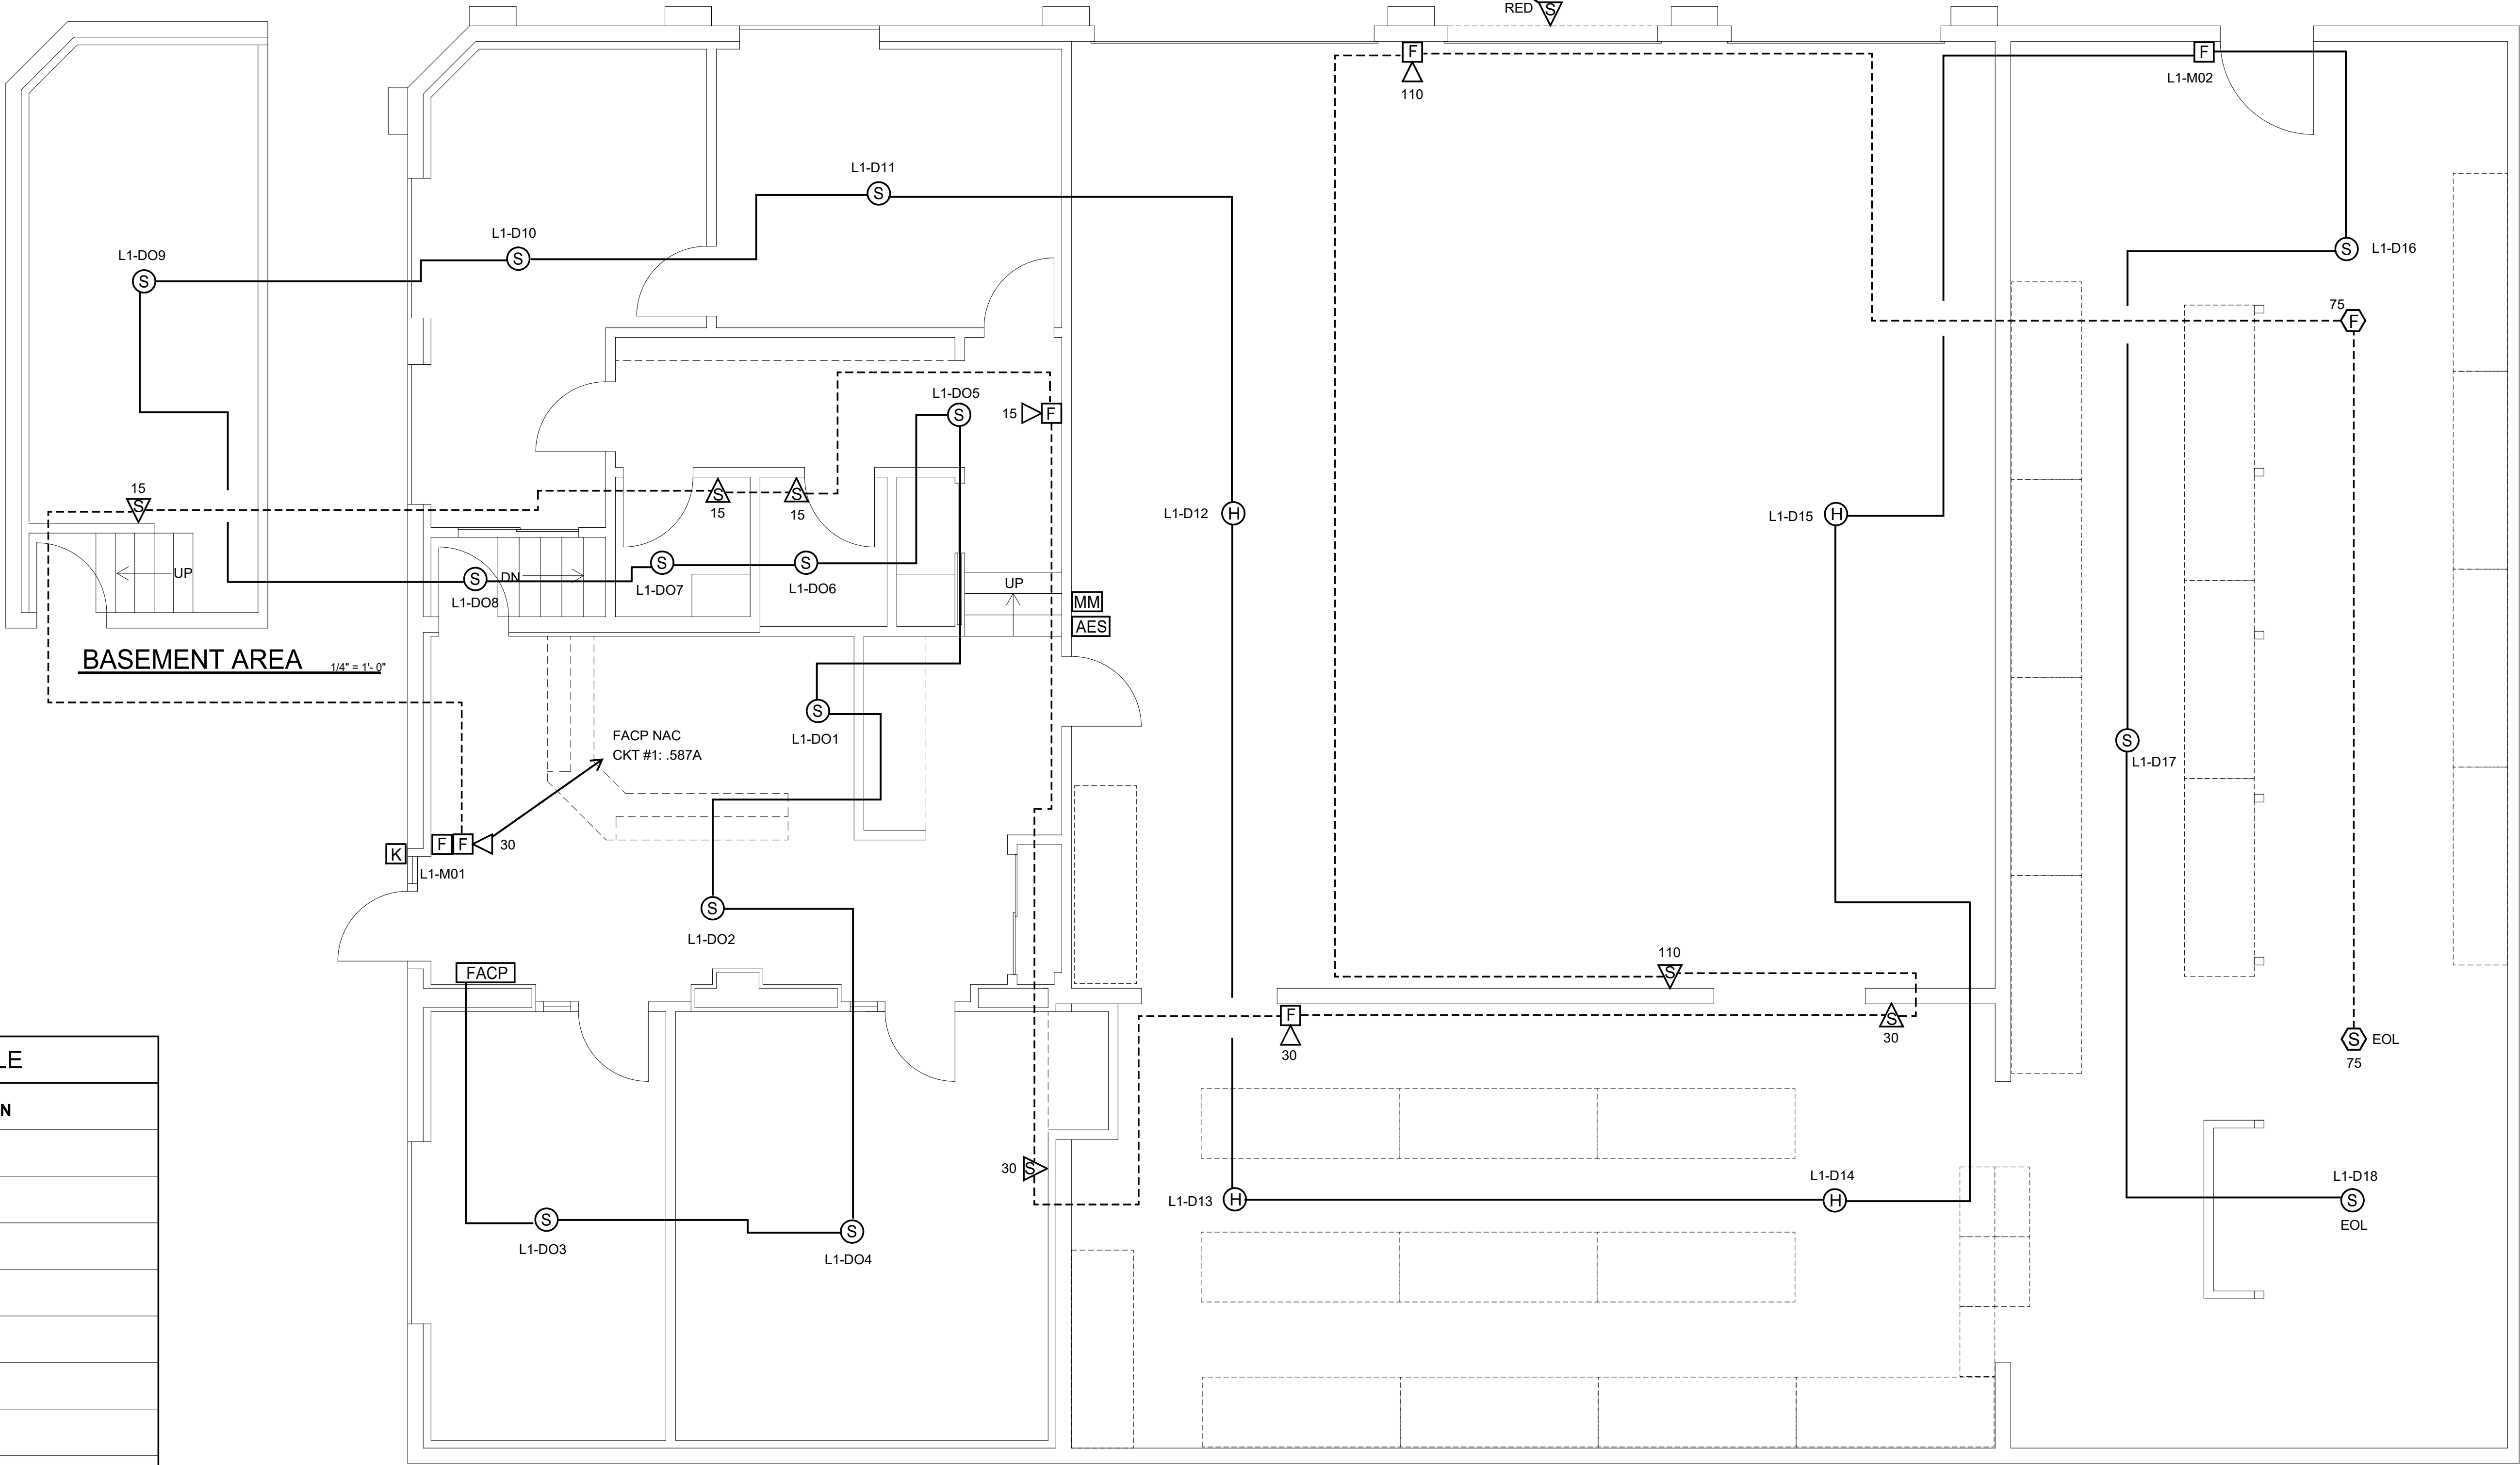

FIRE ALARM PLAN

1/4" = 1'-0"

REVISIONS

1.	
2.	
3.	
4.	
5.	
6.	

THESE DRAWINGS ARE THE PROPERTY OF DEMAND ELECTRIC, INC. ANY REPRODUCTION OF THESE DRAWINGS WITHOUT WRITTEN CONSENT IS PROHIBITED. THESE DRAWINGS DEPICT ELECTRICAL SYSTEMS ONLY. ALL DIMENSIONAL INFORMATION SHOULD BE SCALED FROM ARCHITECTURAL DRAWINGS.

711 VALLEY ST. ASSOCIATES

711 VALLEY ST
MANCHESTER, NH 03103

TELE: (603) 625-2309 FAX: (603) 626-1229

QUALITY ELECTRICAL CONSTRUCTION AND SERVICE

INC.

DESCRIPTION: FIRE ALARM PLAN		CHECKED BY:	SIZE
DRAWN BY: R.J.L.	SCALE: AS SHOWN		
DATE: 08/18/25	JOB#: ???? ?		D

SHEET

FA1